
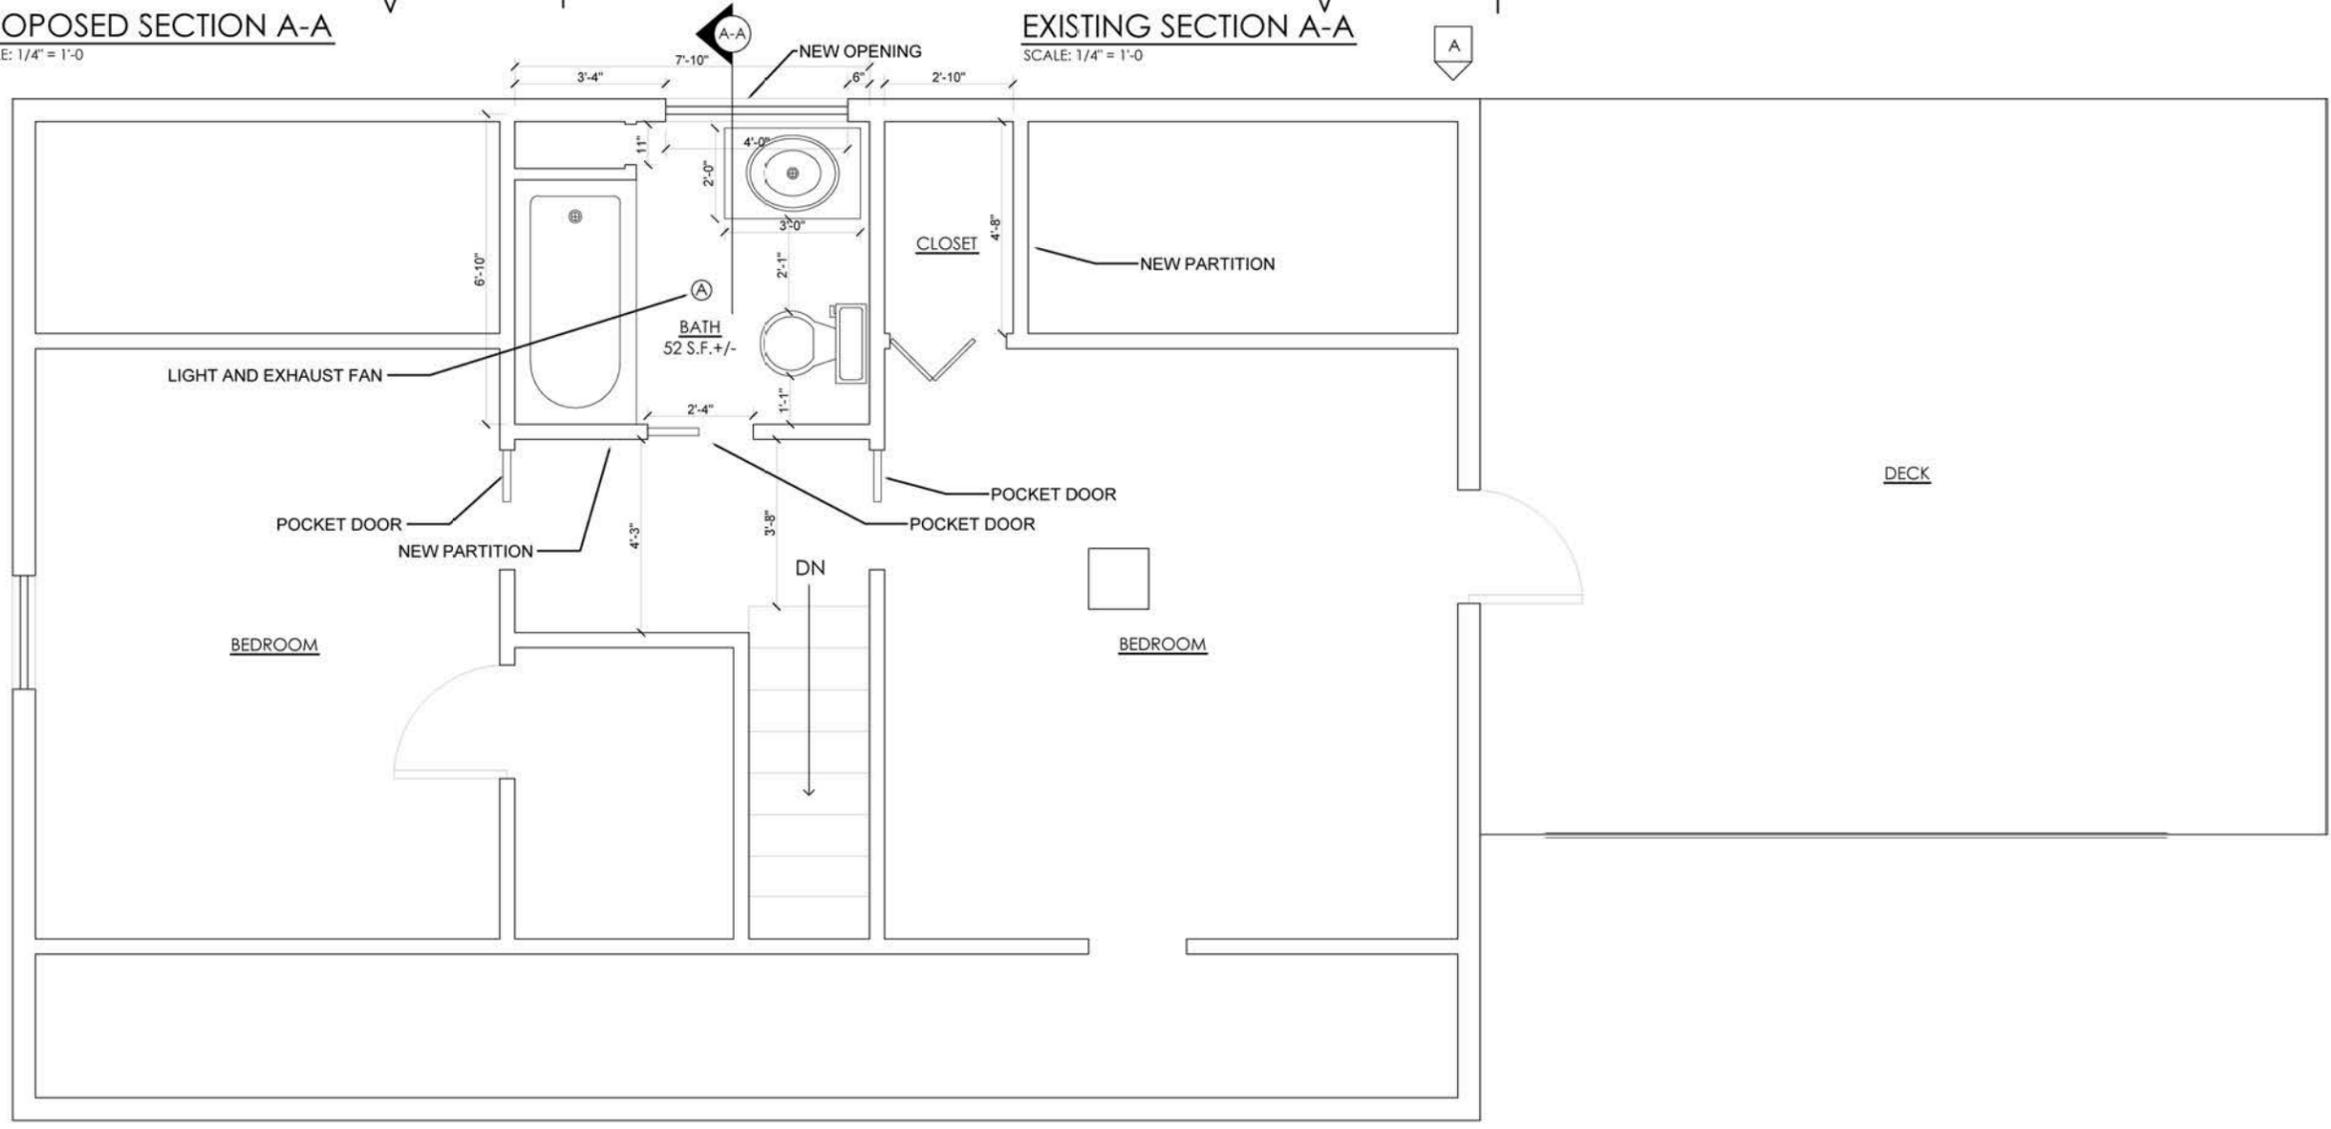
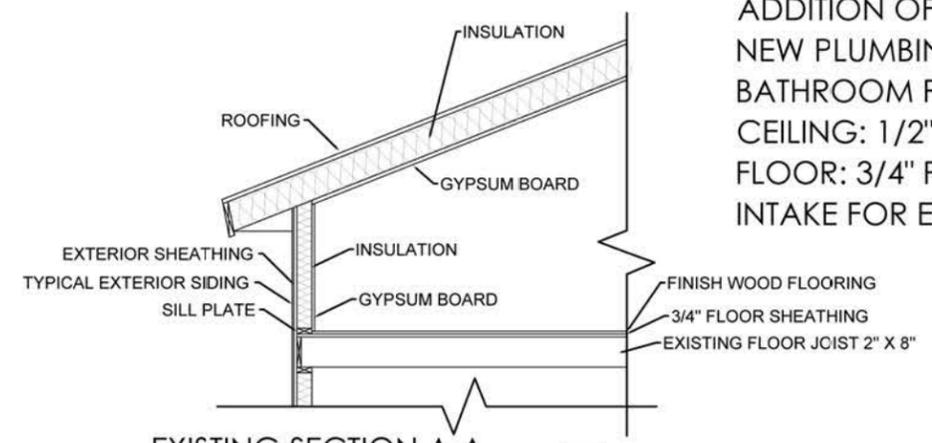


DATE: NOVEMBER 8, 2012
 SCALE: 1/4" = 1'-0"
 DRAWN BY: ALEX CORBETT
 114 ALEXANDER AVENUE
 BELMONT, MA 02478
 617.283.8972

GENERAL NOTES:


- ADDITION OF EXTERIOR WALL WITH NEW OPENING AS SHOWN
- ADDITION OF TWO INTERIOR PARTITION WALLS AS SHOWN
- ADDITION OF NEW GLASS BLOCK WINDOW
- NEW PLUMBING FIXTURES SHOWN IN PLAN
- BATHROOM PARTITIONS: 1/2" BLUE GWB
- CEILING: 1/2" BLUE GWB
- FLOOR: 3/4" PLYWOOD. FINISH MATERIAL WILL BE TILES
- INTAKE FOR EXHAUST FAN LOCATED AT SOUTH EXTERIOR WALL

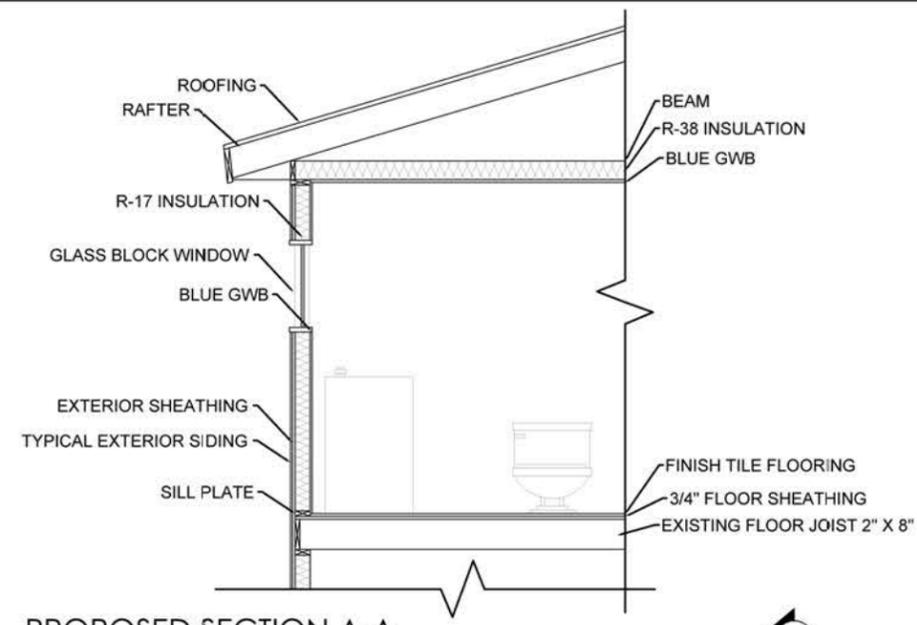

REVISION:	DATE:

DRAWING TITLE:
 BATHROOM PLAN

SHEET NUMBER:
A2

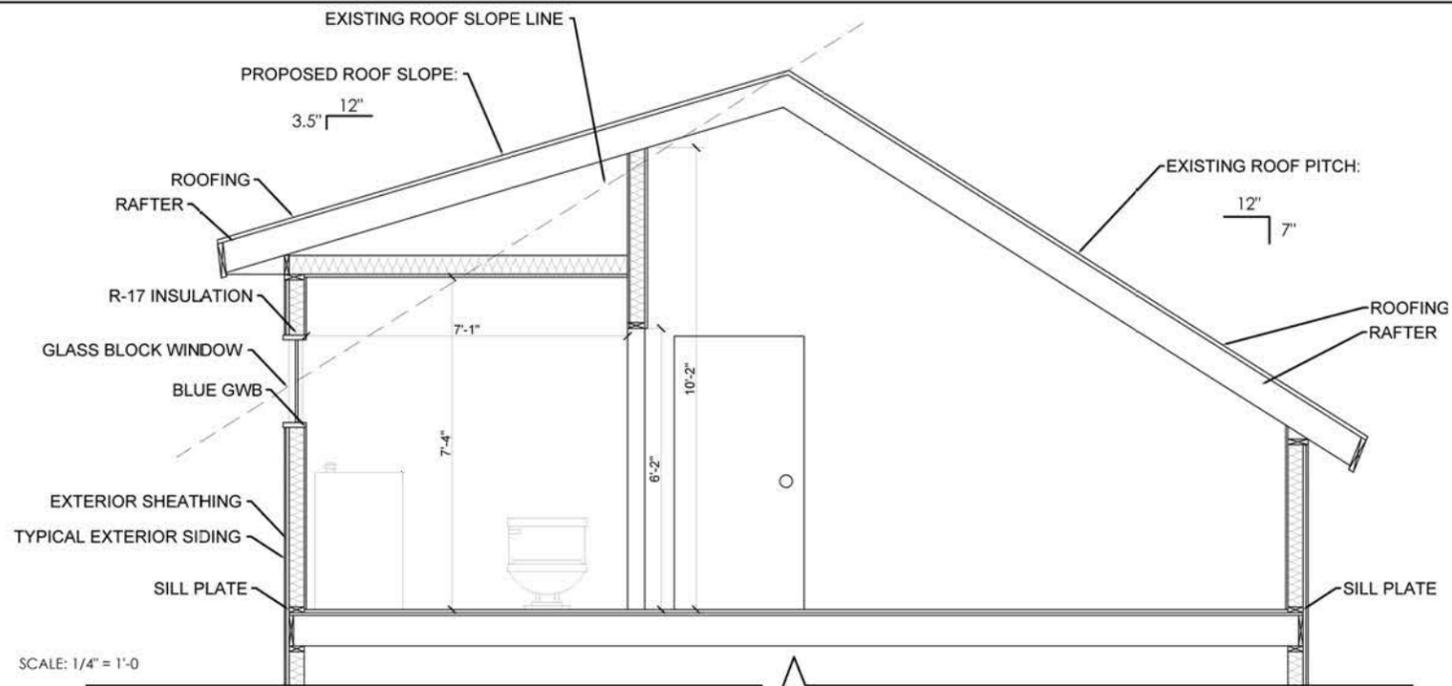


PROPOSED SECTION A-A

SCALE: 1/4" = 1'-0"

GENERAL NOTES:

- ADDITION OF EXTERIOR WALL WITH NEW OPENING AS SHOWN
- ADDITION OF TWO INTERIOR PARTITION WALLS AS SHOWN
- ADDITION OF NEW GLASS BLOCK WINDOW
- NEW PLUMBING FIXTURES SHOWN IN PLAN
- BATHROOM PARTITIONS: 1/2" BLUE GWB
- CEILING: 1/2" BLUE GWB
- FLOOR: 3/4" PLYWOOD. FINISH MATERIAL WILL BE TILES
- INTAKE FOR EXHAUST FAN LOCATED AT SOUTH EXTERIOR WALL

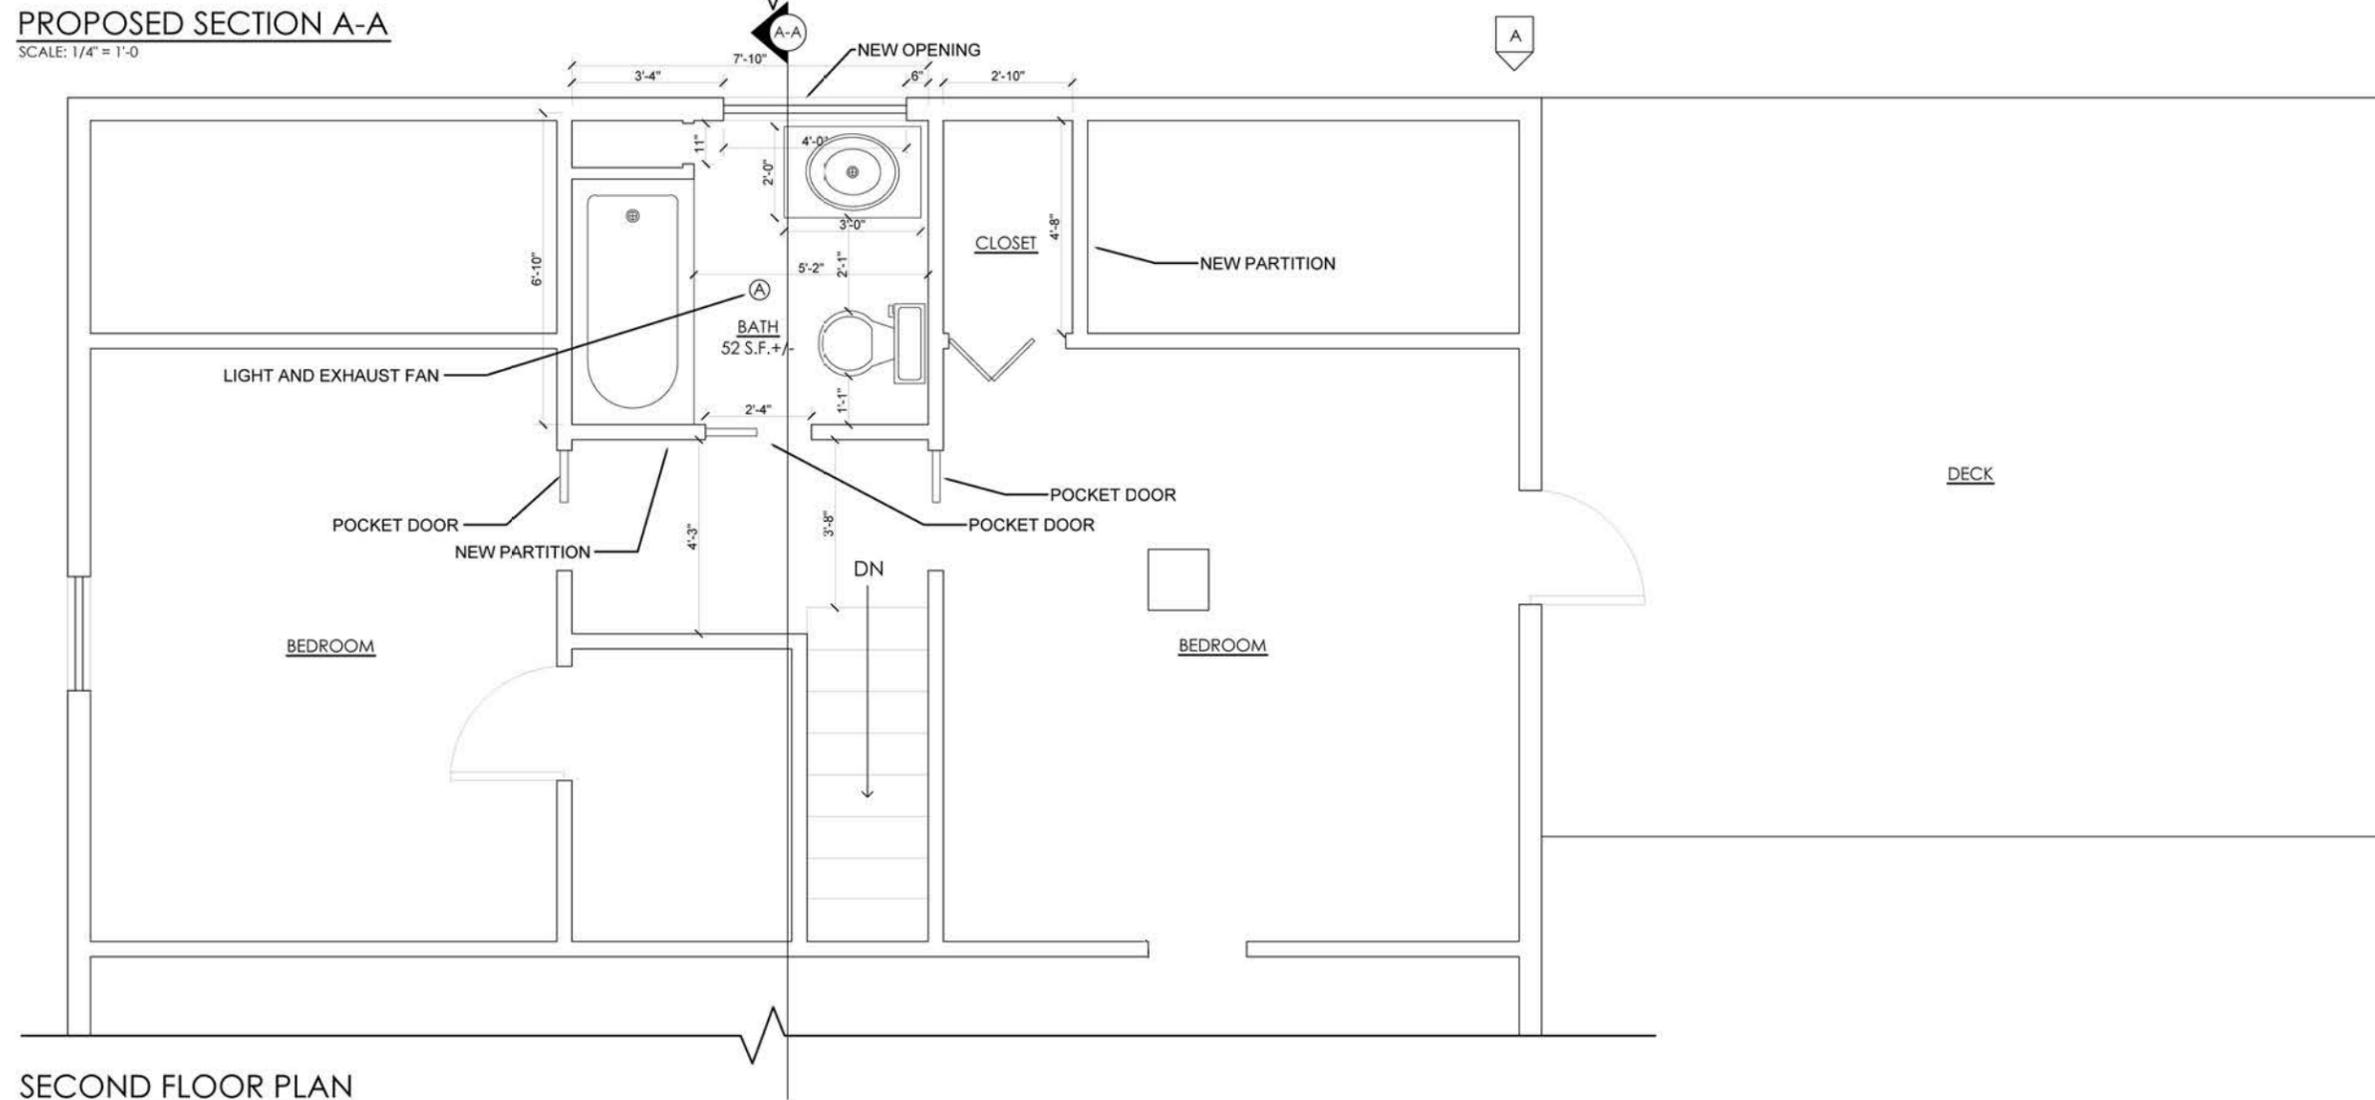

SECOND FLOOR PLAN

SCALE: 1/4" = 1'-0"

BOYLE BATHROOM REMODELING
 9 KINGMAN STREET
 SOMERVILLE, MA 02143

DATE: NOVEMBER 8, 2012

SCALE: 1/4" = 1'-0"

DRAWN BY: ALEX CORBETT
 114 ALEXANDER AVENUE
 BELMONT, MA 02478
 617.283.8972

REVISION:	DATE:


DRAWING TITLE:
BATHROOM PLAN & SECTION

SHEET NUMBER:

A3

GENERAL NOTES:

- ADDITION OF EXTERIOR WALL WITH NEW OPENING AS SHOWN
- ADDITION OF TWO INTERIOR PARTITION WALLS AS SHOWN
- ADDITION OF NEW GLASS BLOCK WINDOW
- GLASS BLOCK WINDOW IS FIRE RATED AND DIMENSIONS ARE 1' X 4'
- ELEVATION SHOWS PROPOSED REAR ROOF DECK

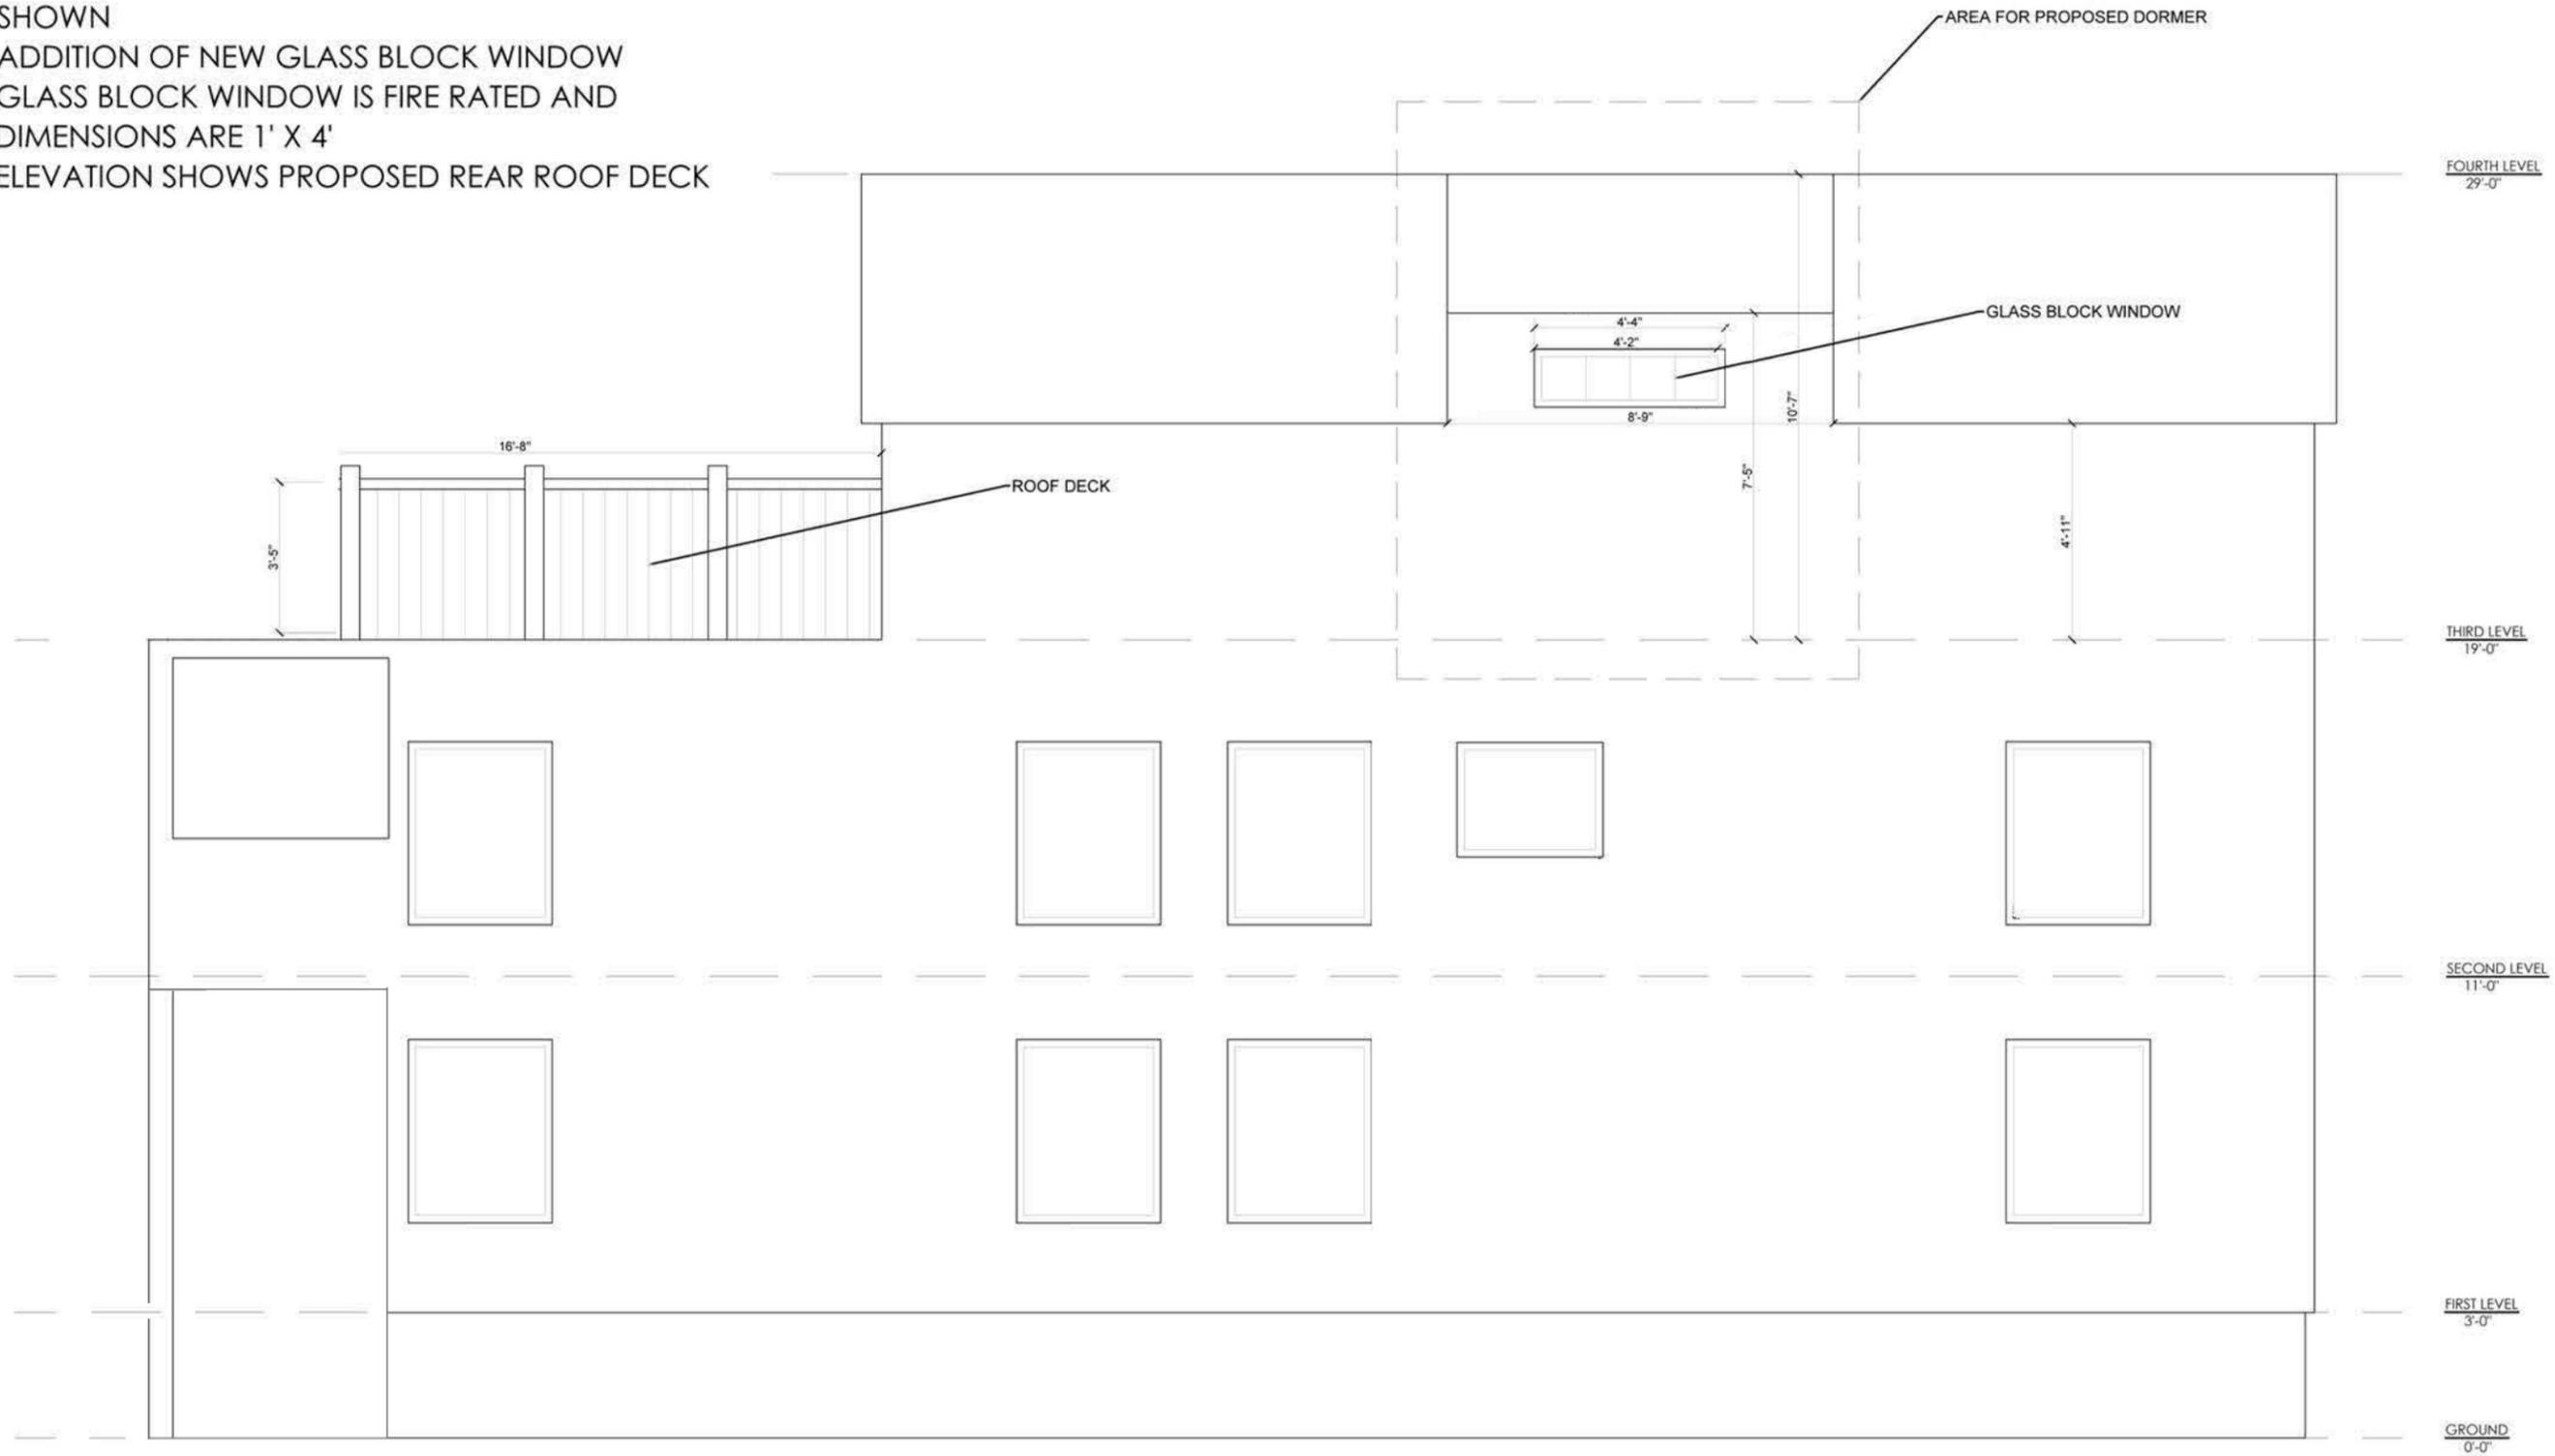

BOYLE BATHROOM REMODELING
 9 KINGMAN STREET
 SOMERVILLE, MA 02143

DATE: NOVEMBER 8, 2012

SCALE: 1/4" = 1'-0"

DRAWN BY: ALEX CORBETT
 114 ALEXANDER AVENUE
 BELMONT, MA 02478
 617.283.8972

REVISION:	DATE:


DRAWING TITLE:

ELEVATION


SHEET NUMBER:

A4

ELEVATION A
 SCALE: 1/4" = 1'-0"

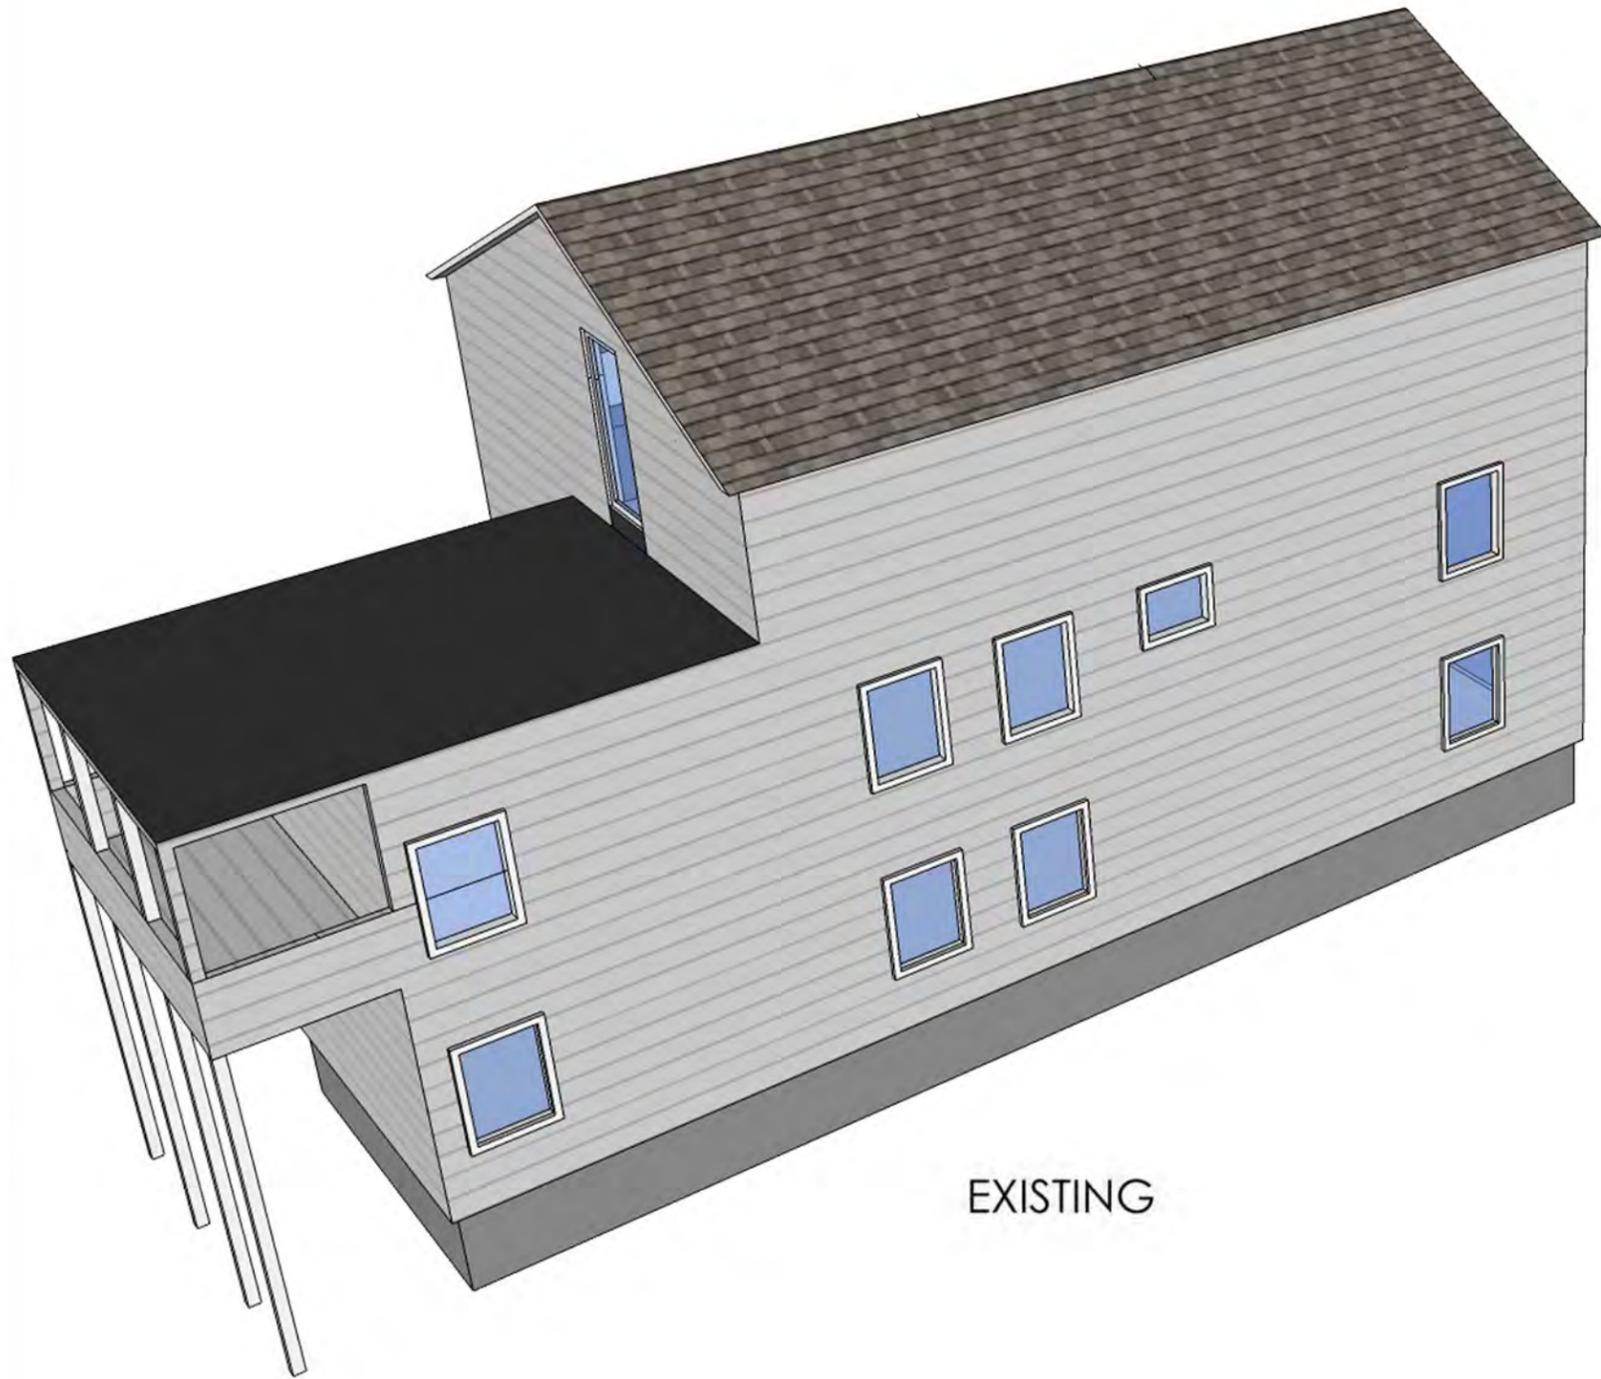

EXISTING

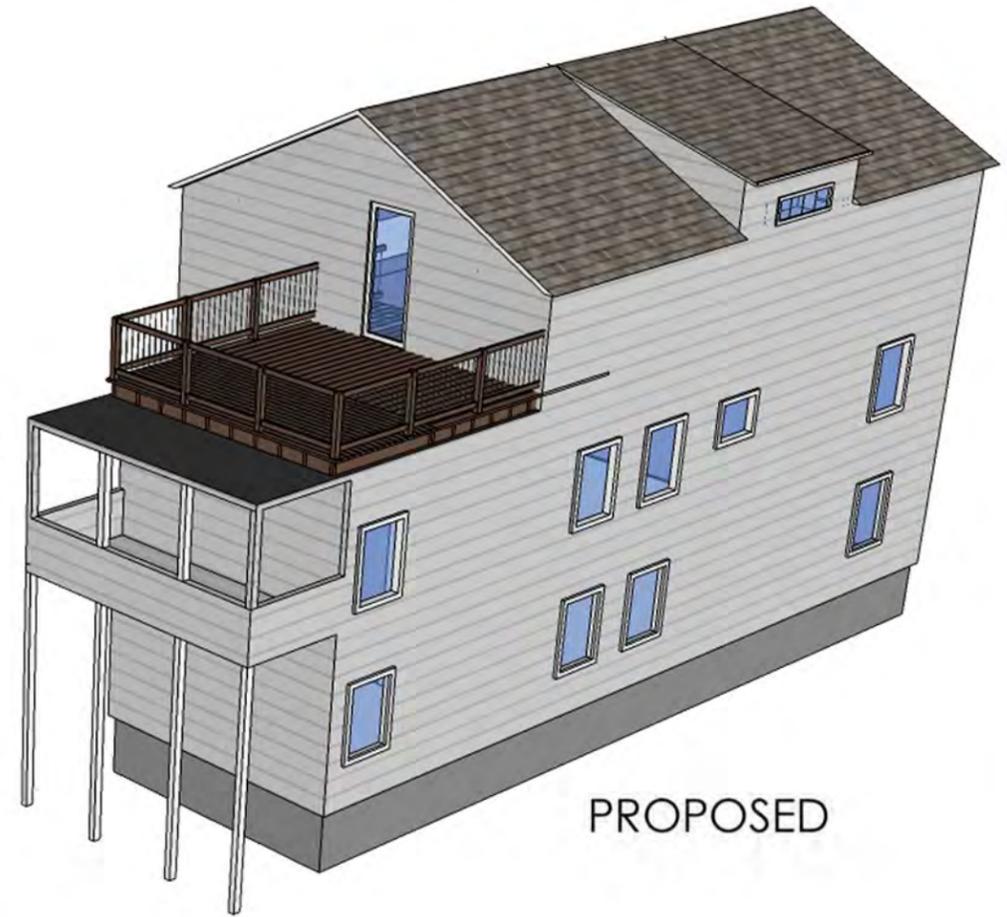

PROPOSED

BOYLE DECK PROPOSAL
9 KINGMAN STREET
SOMERVILLE, MA 02143

DATE: JULY 16, 2012
SCALE: 1/8" = 1'-0"
DRAWN BY: ALEX CORBETT

ALEX CORBETT
114 ALEXANDER AVENUE
BELMONT, MA 02478
617.283.8972

REVISION:	DATE:

DRAWING TITLE:
PERSPECTIVE RENDERS

SHEET NUMBER:
R1

BOYLE DECK PROPOSAL
9 KINGMAN STREET
SOMERVILLE, MA 02143

DATE: JULY 16, 2012
SCALE: 1/8" = 1'-0"
DRAWN BY: ALEX CORBETT



ALEX CORBETT
114 ALEXANDER AVENUE
BELMONT, MA 02478
617.283.8972

REVISION:	DATE:

DRAWING TITLE:
ELEVATION RENDERS

SHEET NUMBER:
R2

REVISION:	DATE:

DRAWING TITLE:
 DECK PLAN

SHEET NUMBER:
D1

