

- KEY**
- EXISTING WALL
  - NEW WALL


- GENERAL NOTES:**
- ALL WORK AS PER STATE BUILDING CODE.
  - MINIMUM DIMENSION FOR STAIRS, PASSAGES & BATHROOMS AS PER BUILDING CODE.
  - SEE STRUCTURAL DWGS FOR ALL STRUCTURAL NOTES.
  - SEE ELECTRICAL PLANS FOR ALL FIRE/SMOKE/MONOXIDE DETECTORS.

457 MEDFORD STREET RENOVATIONS  
 457 MEDFORD STREET  
 SOMERVILLE, MA 02145

**DONALDSON CONSTRUCTION & DEVELOPMENT**  
 24 MONTGOMERY STREET  
 CAMBRIDGE, MA  
 CONTACT HENRY L. DONALDSON  
 TELEPHONE 914-671-4141  
 EMAIL HLLDD@HOTMAIL.COM

**BASEMENT LEVEL  
 CONSTRUCTION PLAN**

SCALE: 1/4" = 1'-0"  
 DATE: 03.10.14  
 ISSUE

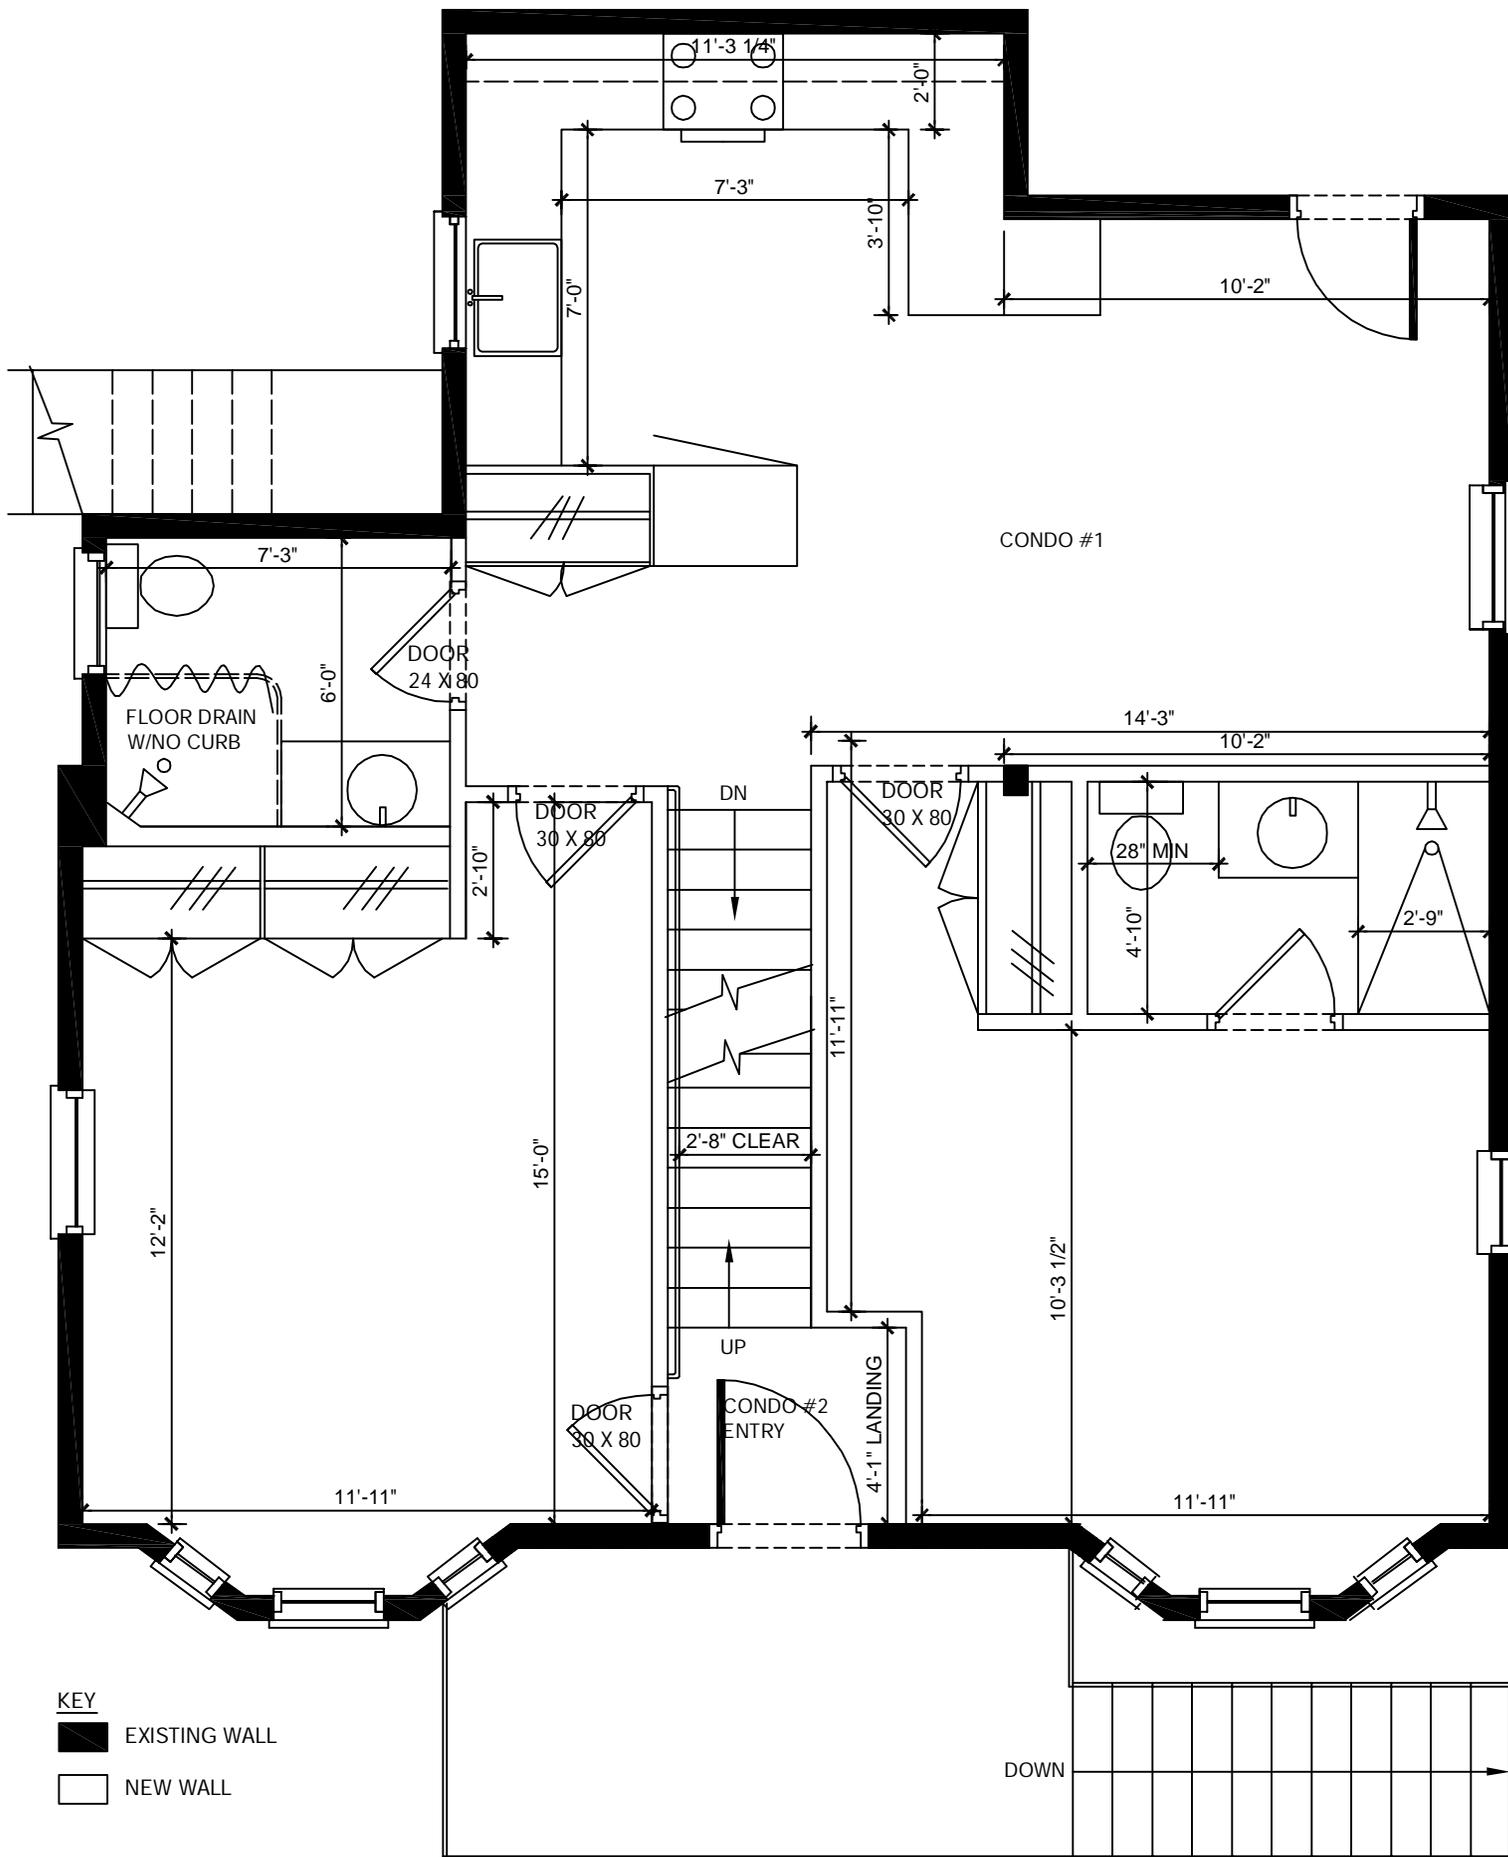

- KEY**
- EXISTING WALL
  - NEW WALL

**GENERAL NOTES:**


- ALL WORK AS PER STATE BUILDING CODE.
- MINIMUM DIMENSION FOR STAIRS, PASSAGES & BATHROOMS AS PER BUILDING CODE.
- SEE STRUCTURAL DWGS FOR ALL STRUCTURAL NOTES.
- SEE ELECTRICAL PLANS FOR ALL FIRE/SMOKE/MONOXIDE DETECTORS.

457 MEDFORD STREET RENOVATIONS  
 457 MEDFORD STREET  
 SOMERVILLE, MA 02145

FIRST FLOOR  
 CONSTRUCTION PLAN

DONALDSON CONSTRUCTION &  
 DEVELOPMENT  
 24 MONTGOMERY STREET  
 CAMBRIDGE, MA  
 CONTACT HENRY L. DONALDSON  
 TELEPHONE 914-671-4141  
 EMAIL HLLDD@HOTMAIL.COM

SCALE: 1/4" = 1'-0"  
 DATE: 03.10.14  
 ISSUE

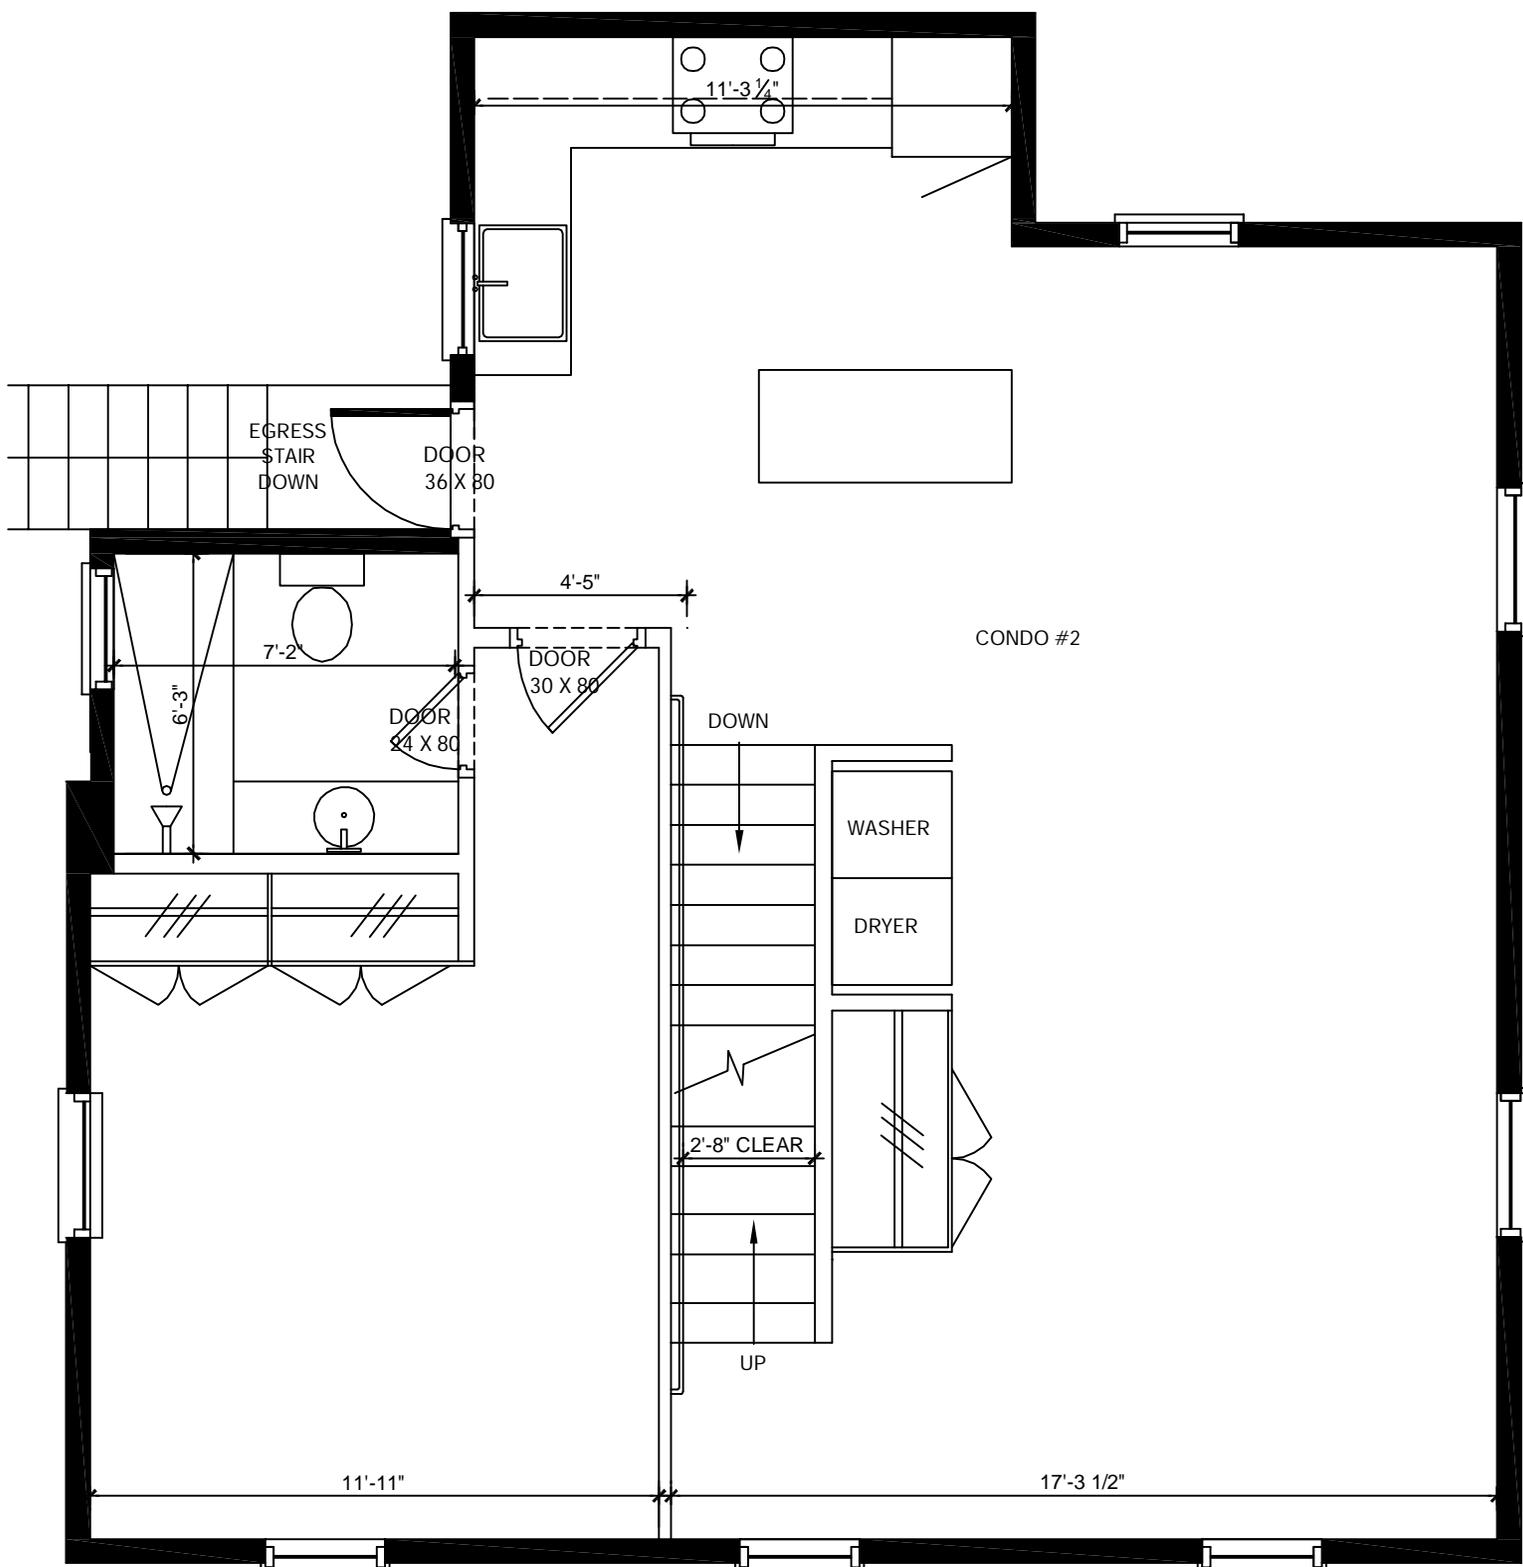

**KEY**

- EXISTING WALL
- NEW WALL

**GENERAL NOTES:**


- ALL WORK AS PER STATE BUILDING CODE.
- MINIMUM DIMENSION FOR STAIRS, PASSAGES & BATHROOMS AS PER BUILDING CODE.
- SEE STRUCTURAL DWGS FOR ALL STRUCTURAL NOTES.
- SEE ELECTRICAL PLANS FOR ALL FIRE/SMOKE/MONOXIDE DETECTORS.

457 MEDFORD STREET RENOVATIONS  
 457 MEDFORD STREET  
 SOMERVILLE, MA 02145

SECOND FLOOR  
 CONSTRUCTION PLAN

DONALDSON CONSTRUCTION &  
 DEVELOPMENT  
 24 MONTGOMERY STREET  
 CAMBRIDGE, MA  
 CONTACT HENRY L. DONALDSON  
 TELEPHONE 914-671-4141  
 EMAIL HLLDD@HOTMAIL.COM

SCALE: 1/4" = 1'-0"  
 DATE: 03.10.14  
 ISSUE

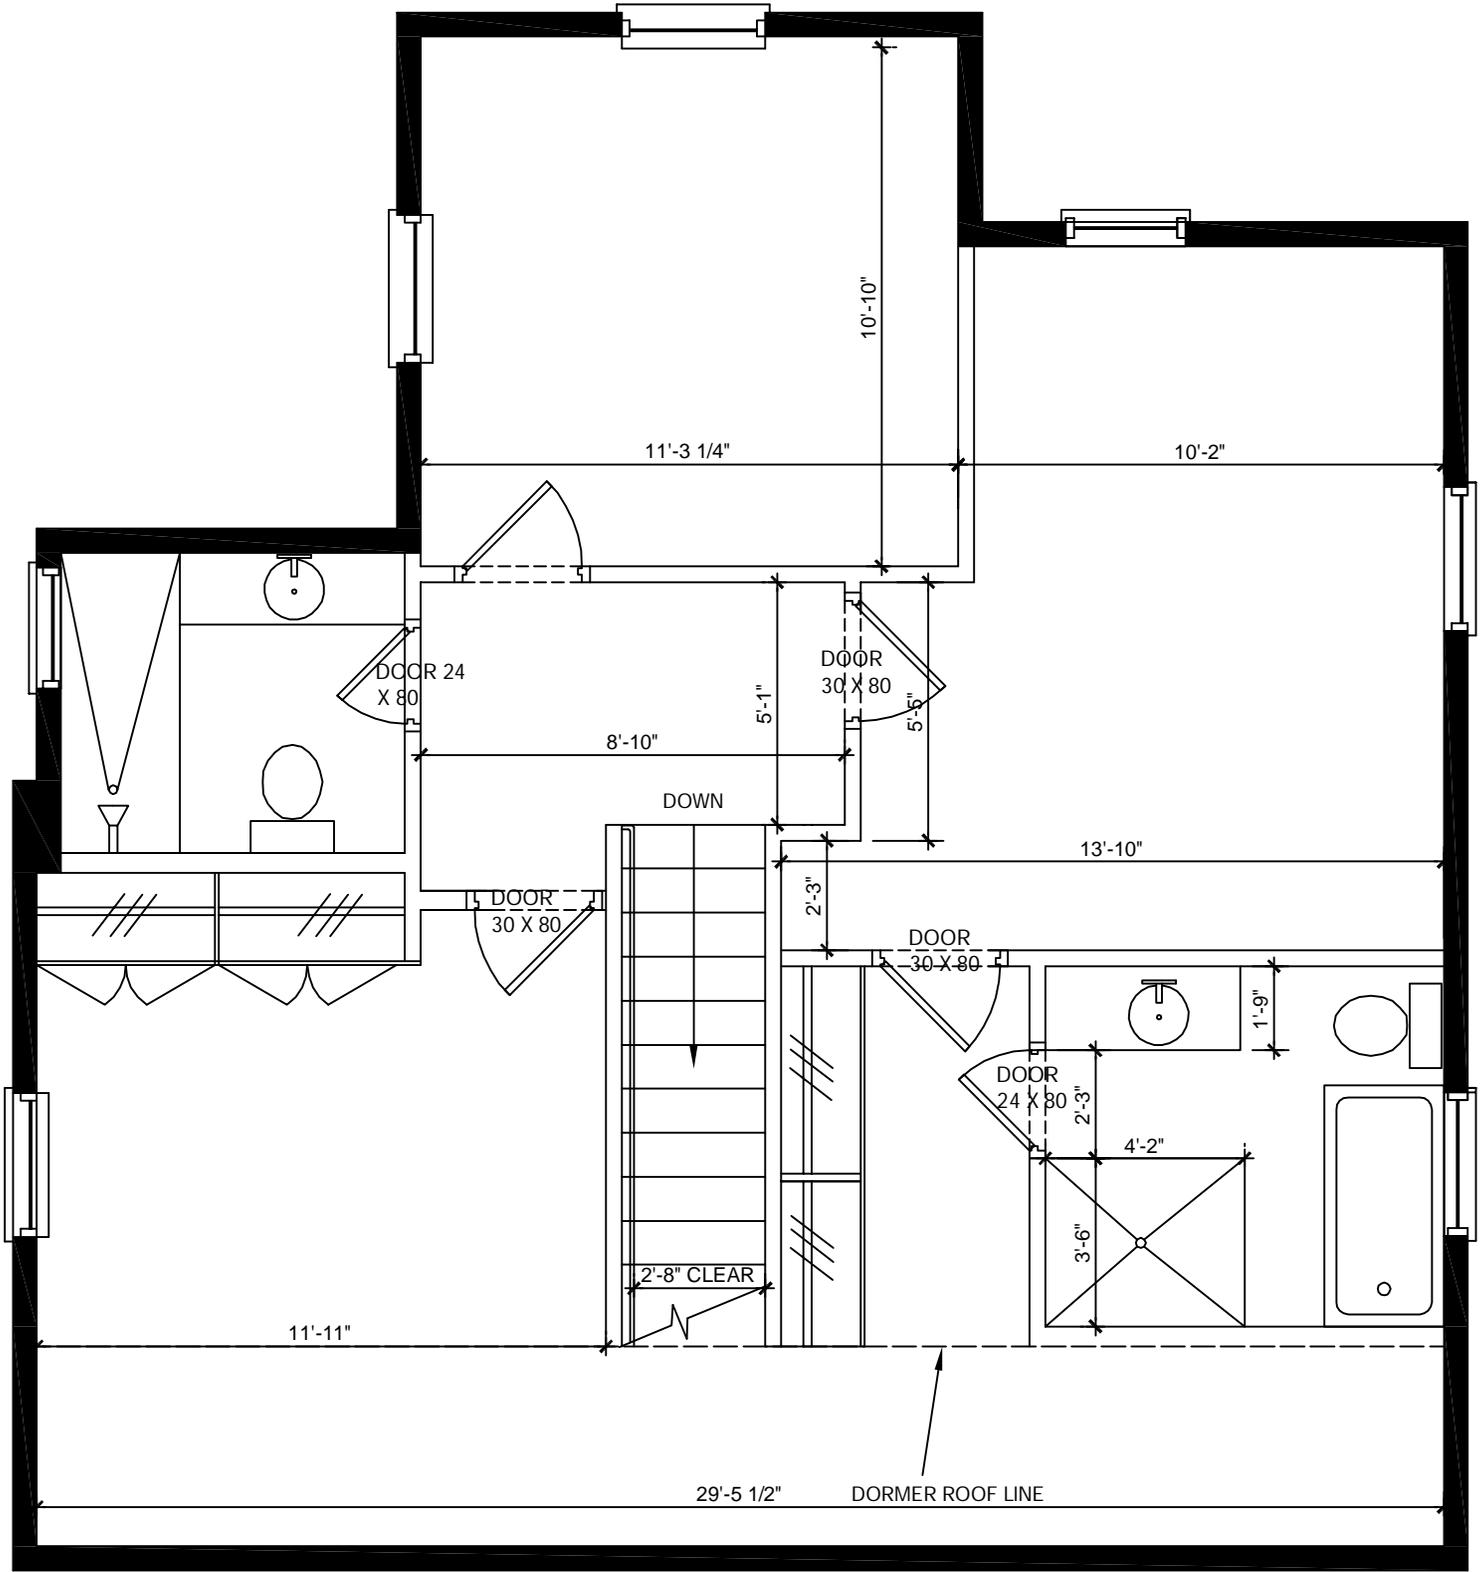

**KEY**

-  EXISTING WALL
-  NEW WALL

**GENERAL NOTES:**

- ALL WORK AS PER STATE BUILDING CODE.
- MINIMUM DIMENSION FOR STAIRS, PASSAGES & BATHROOMS AS PER BUILDING CODE.
- SEE STRUCTURAL DWGS FOR ALL STRUCTURAL NOTES.
- SEE ELECTRICAL PLANS FOR ALL FIRE/SMOKE/MONOXIDE DETECTORS.

457 MEDFORD STREET RENOVATIONS  
 457 MEDFORD STREET  
 SOMERVILLE, MA 02145

THIRD FLOOR  
 CONSTRUCTION PLAN

DONALDSON CONSTRUCTION &  
 DEVELOPMENT  
 24 MONTGOMERY STREET  
 CAMBRIDGE, MA  
 CONTACT HENRY L. DONALDSON  
 TELEPHONE 914-671-4141  
 EMAIL HLLDD@HOTMAIL.COM

SCALE: 1/4" = 1'-0"  
 DATE: 02.19.14  
 ISSUE